

Legend of Symbols

F1

40W COMPACT PERFORMANCE FLOODLIGHT
C/W MEDIUM BEAM DISTRIBUTION AND G $\frac{1}{2}$ MOUNTING BUSH

DENOTES AIMING POSITION SHOWN
WHEN AIMED AT GROUND LEVEL

IF AIMING POSITION NOT SHOWN - LUMINAIRE IS TO BE AIMED
UPWARD OF BUILDING, DIRECTED AT $\frac{2}{3}$ OF TOTAL BUILDING HEIGHT

COLOUR TEMPERATURE: 3000K
INGRESS PROTECTION: IP65
IMPACT PROTECTION: IK09

DETAILS: "BEGA - 84528 3000K"

L1

9.8W LED INGROUND ZOOM AND DIRECTIONAL LUMINAIRE
REFER DATA SHEET IN SPECIFICATION APPENDICES
FOR FURTHER DETAILS

IMPACT PROTECTION: IK11
INGRESS PROTECTION: IP68

DETAILS: "ERCO - TESIS"
CAT. No. B2000038

LP

NEW ALUMINIUM POLE WITH BASE PLATE
FOR EXTERNAL LIGHTING
GRAPHITE FINISH - REFER DATA SHEET IN APPENDICES
AND DRAWING "T111B E-130" FOR FURTHER DETAILS

CAT. No. "BEGA - 70 797 + 70 899"
CONFIRM ANCHORAGE UNITS REQUIREMENTS
WITH STRUCTURAL ENGINEER BEFORE ORDERING

POLE ADAPTER DETAILS:

(FOR MOUNTING OF FLOODLIGHT)
C/W G $\frac{1}{2}$ THREADED CONNECTION (ISO 228) ON POLE
REQUIRED RECESSED OPENING OF 30mm DIAMETER

DIMENSIONS: 40x40x40mm
CAT. No. "BEGA POLE ADAPTER 71042"

L2

EXISTING LINEAR LUMINAIRE
TO BE REPLACED WITH NEW 18W LED BATTEN

DETAILS: "PIERLITE - BWP ECO WEATHERPROOF BATTEN GEN 2"
CAT. No. BWPEC020ZCS 18W-4000K SELECTION

S1

NEW 13W LED STREET LIGHTING LUMINAIRE
C/W P.E. CELL TO BE INSTALLED ON WALL AT 5m AFL

DETAILS: "SYLVANIA - STREETLED 3 + P.E. CELL"

W1

14W LED WALL LUMINAIRE
MOUNTED ABOVE TOP STEP AT A HEIGHT OF 800mm AFL
REFER DATA SHEET IN SPECIFICATION APPENDICES
FOR FURTHER DETAILS

COLOUR TEMPERATURE: 3000K
IMPACT PROTECTION: IK10
INGRESS PROTECTION: IP65
FINISH: GRAPHITE

DETAILS: "BEGA - 22385"

PG

NEW ELECTRICAL PIT
C/W CONCRETE LID TO BE INSTALLED IN GARDEN BED
"CLASS B" RATED (TO AS 3996)
SIZE: 300mm x 300mm OR 400mm DIAMETER

PL

NEW ELECTRICAL PIT - LARGE
"CLASS C" RATED (TO AS 3996)
C/W STEEL LID
SIZE: 600mm x 600mm

NEW ELECTRICAL CONDUIT - INDICATIVE ROUTE
(QUANTITIES AS INDICATED)
ELECTRICAL CONTRACTOR TO SIZE APPROPRIATELY


SP

SUGGESTED SLAB PENETRATION
FROM BASEMENT

Px

LIGHT POLE IDENTIFICATION No.


STATE GOVERNMENT OFFICES
LIGHTING DESIGN • 30 LITTLE MALOP STREET, GEELONG VIC 3220

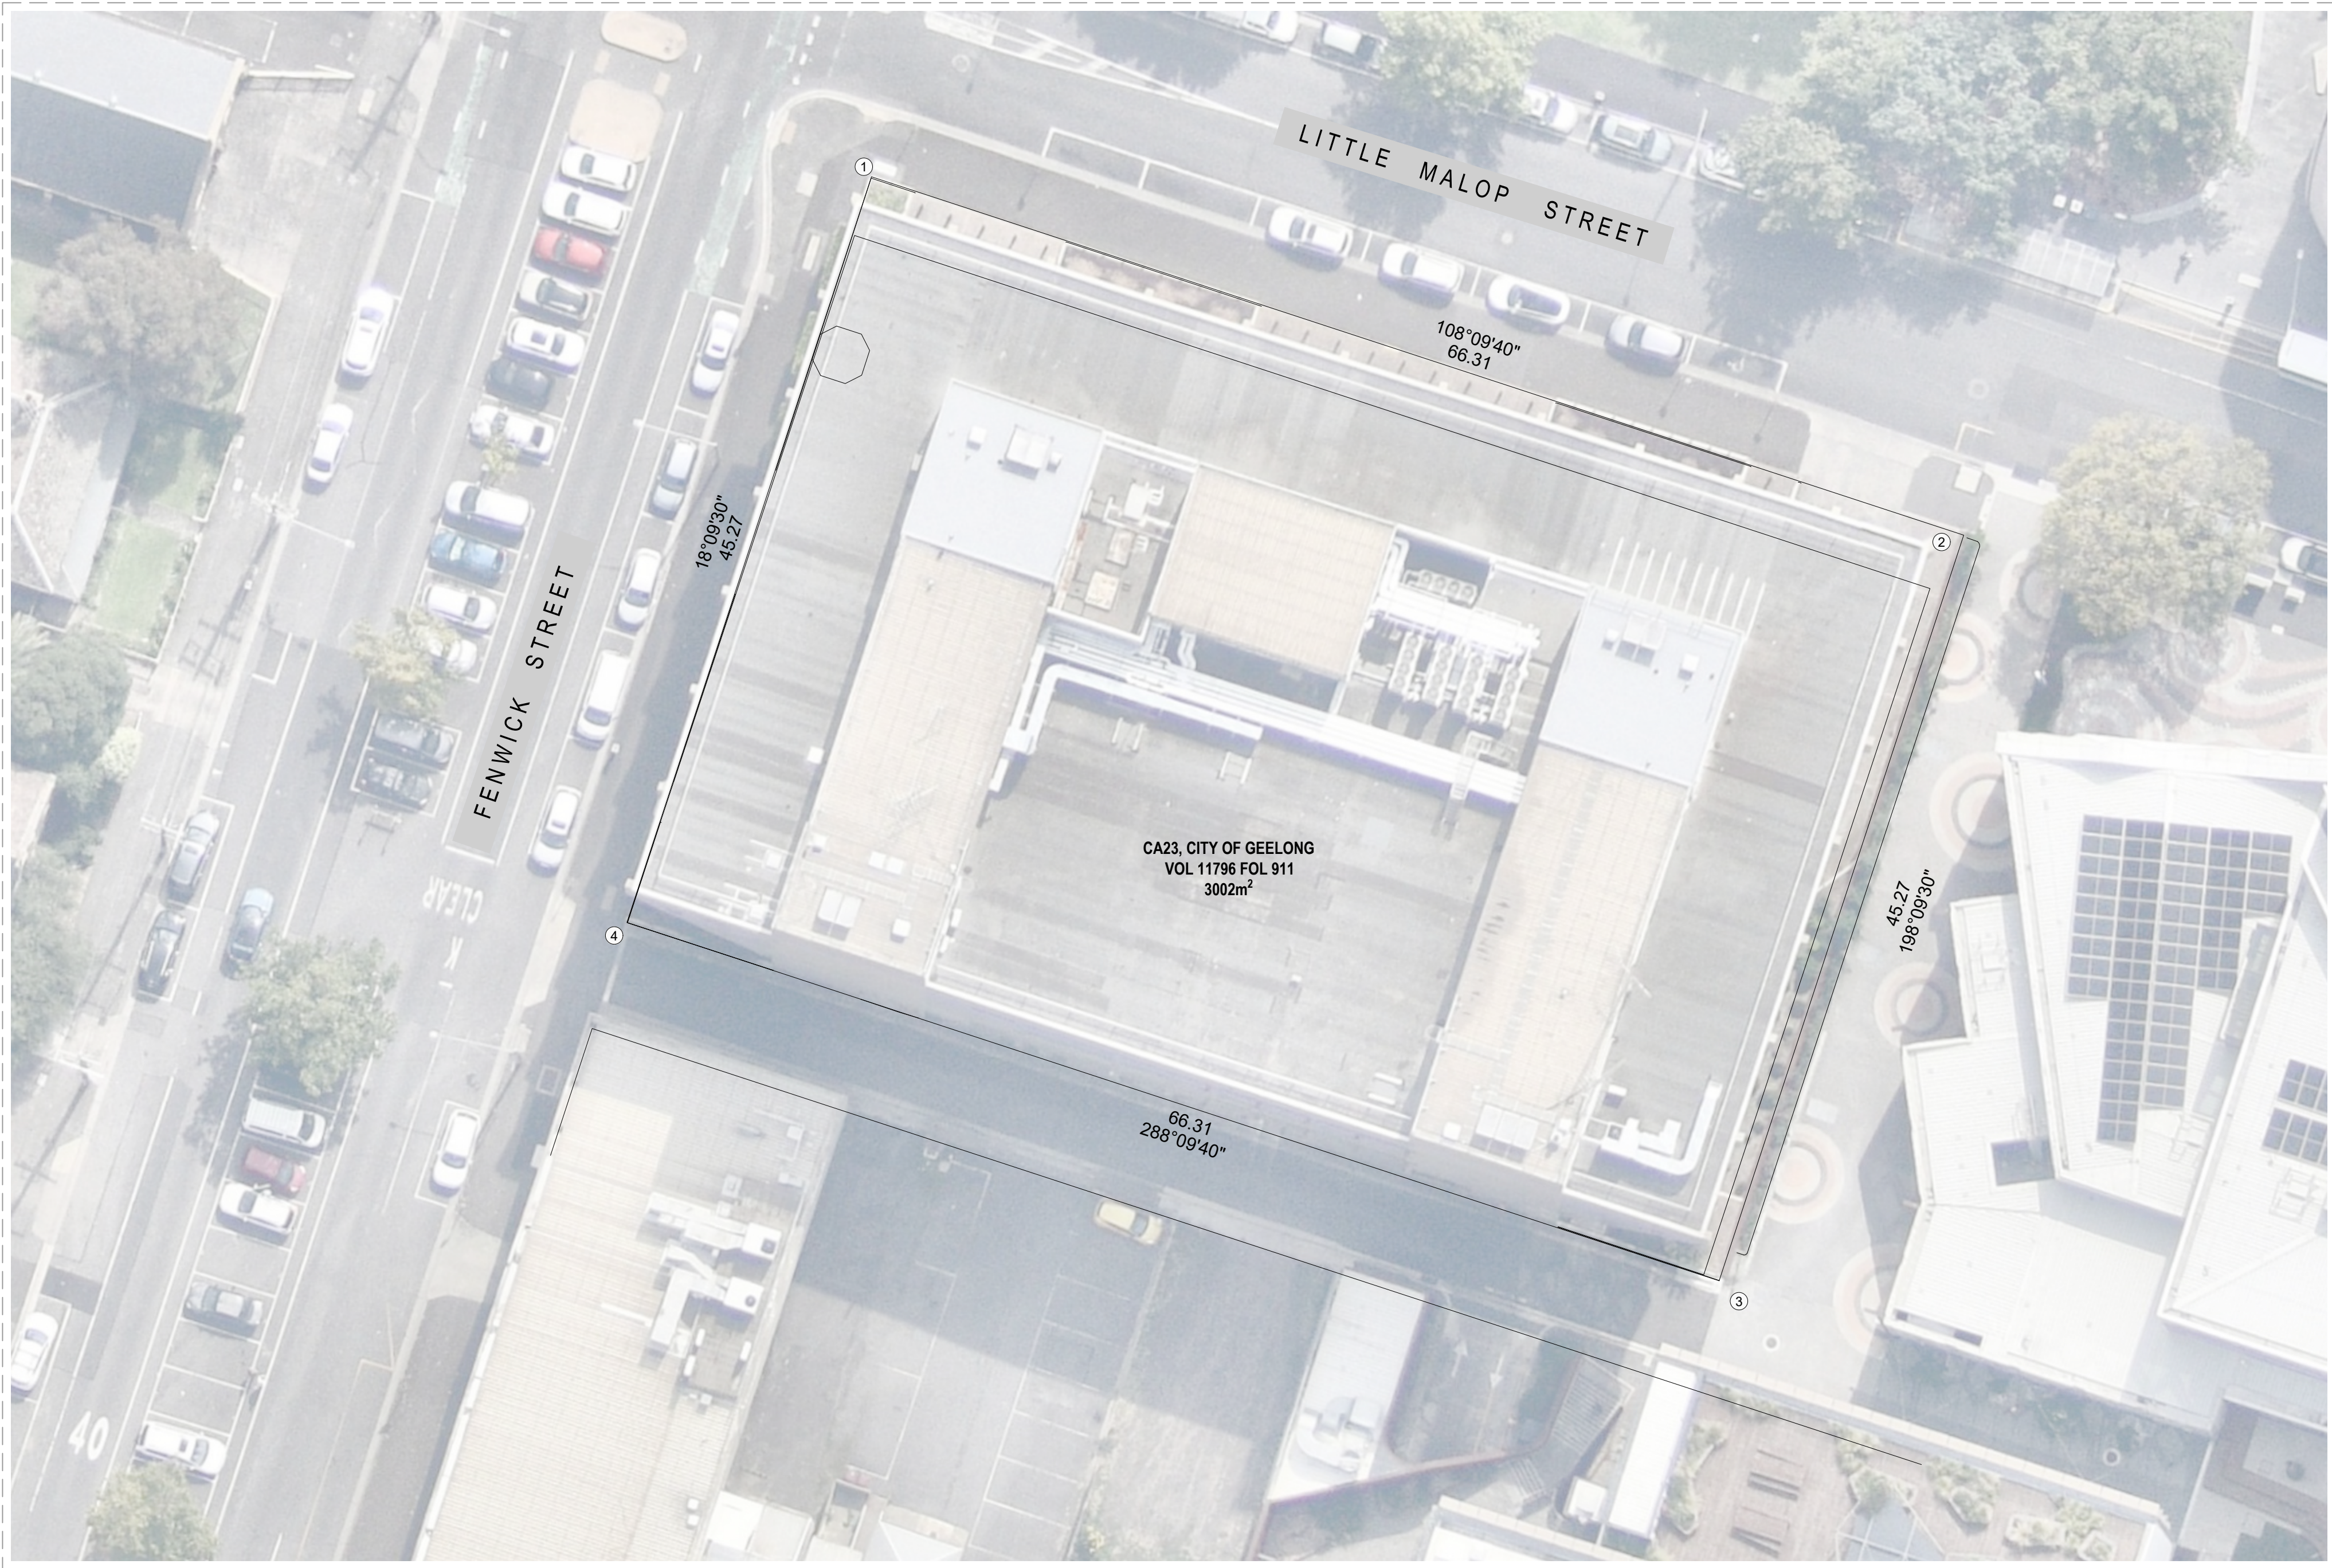

Location Plan
SCALE 1:200 @ A1

Drawing Schedule


T111B E-100	COVER SHEET
T111B E-110	EXTERNAL LIGHTING LAYOUT
T111B E-120	SECURITY DESK AREA - LIGHTING LAYOUT
T111B E-130	SCHEMATIC DIAGRAMS AND DETAILS

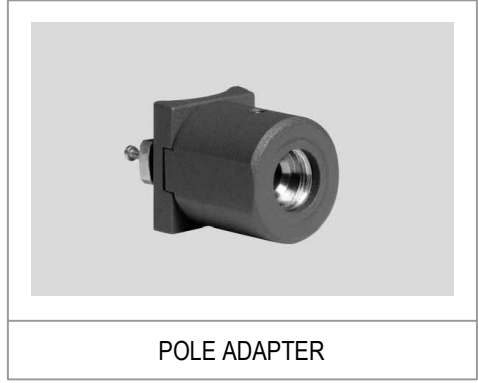


POLE ADAPTER



TYPE F1

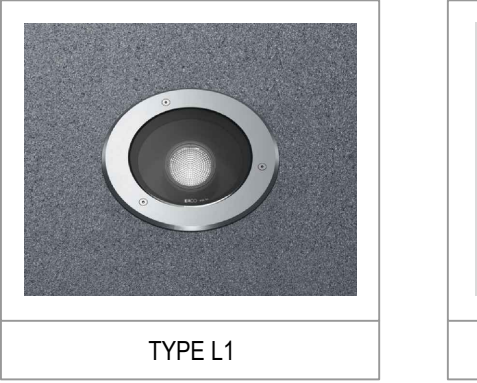


TYPE L1

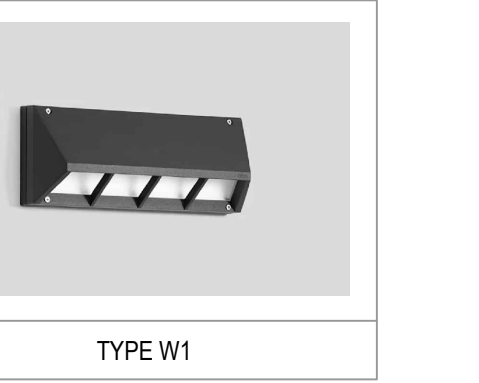

TYPE W1

REVISION	DATE	DES	REV	APP	REVISION	DATE	DES	REV	APP
T1	TENDER ISSUE	06.07.26	R.H.	P.M.	G.L.				
T2	TENDER REVISION	07.08.26	R.H.	P.M.	G.L.				

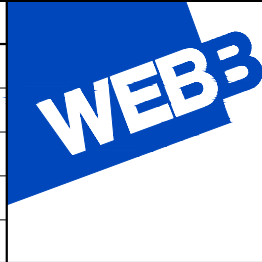

CONSULTING ELECTRICAL ENGINEERS LIGHTING CONSULTANTS
TECHNOLOGY CONSULTANTS
WEBB AUSTRALIA GROUP (VIC) PTY LIMITED ACN 61 073 585 305
LEVEL 9, 128 EXHIBITION STREET MELBOURNE VIC 3000 AUSTRALIA
TELEPHONE 03 9552 0333 EMAIL m.melbourne@webb.australia.com.au
COPYRIGHT © WEBB AUSTRALIA GROUP (VIC) PTY LTD ABN 61 073 585 305. ALL RIGHTS RESERVED. THE DRAWINGS MAY
NOT BE REPRODUCED OR TRANSMITTED IN ANY FORM OR BY ANY MEANS IN PART OR IN WHOLE WITHOUT THE WRITTEN
PERMISSION OF WEBB AUSTRALIA GROUP (VIC) PTY LTD. WEBB AUSTRALIA GROUP DRAWINGS ARE SCHEMATIC AND
SHALL BE USED IN CONJUNCTION WITH ALL CONTRACT DOCUMENTATION. SHOULD ANY AMBIGUITY, ERROR, OMISSION,
DISCREPANCY, INCONSISTENCY OR OTHER FAULT APPEAR TO EXIST IN THE DOCUMENTS, IMMEDIATELY NOTIFY THE
CONTRACT ADMINISTRATOR IN WRITING.

CLIENT

PROJECT DETAILS

DRAWING

conservation
studio


STATE GOVERNMENT OFFICES
30 LT MALOP STREET
GEELONG VIC 3220

COVER SHEET
LEGEND OF SYMBOLS
AND DRAWING SCHEDULE

N


SCALE 1:250 @ A1

JOB No.	DRAWING No.	DRA	REV	APP
T111B	E-100	AP	PM	RH
STATUS				REV
TENDER				T2

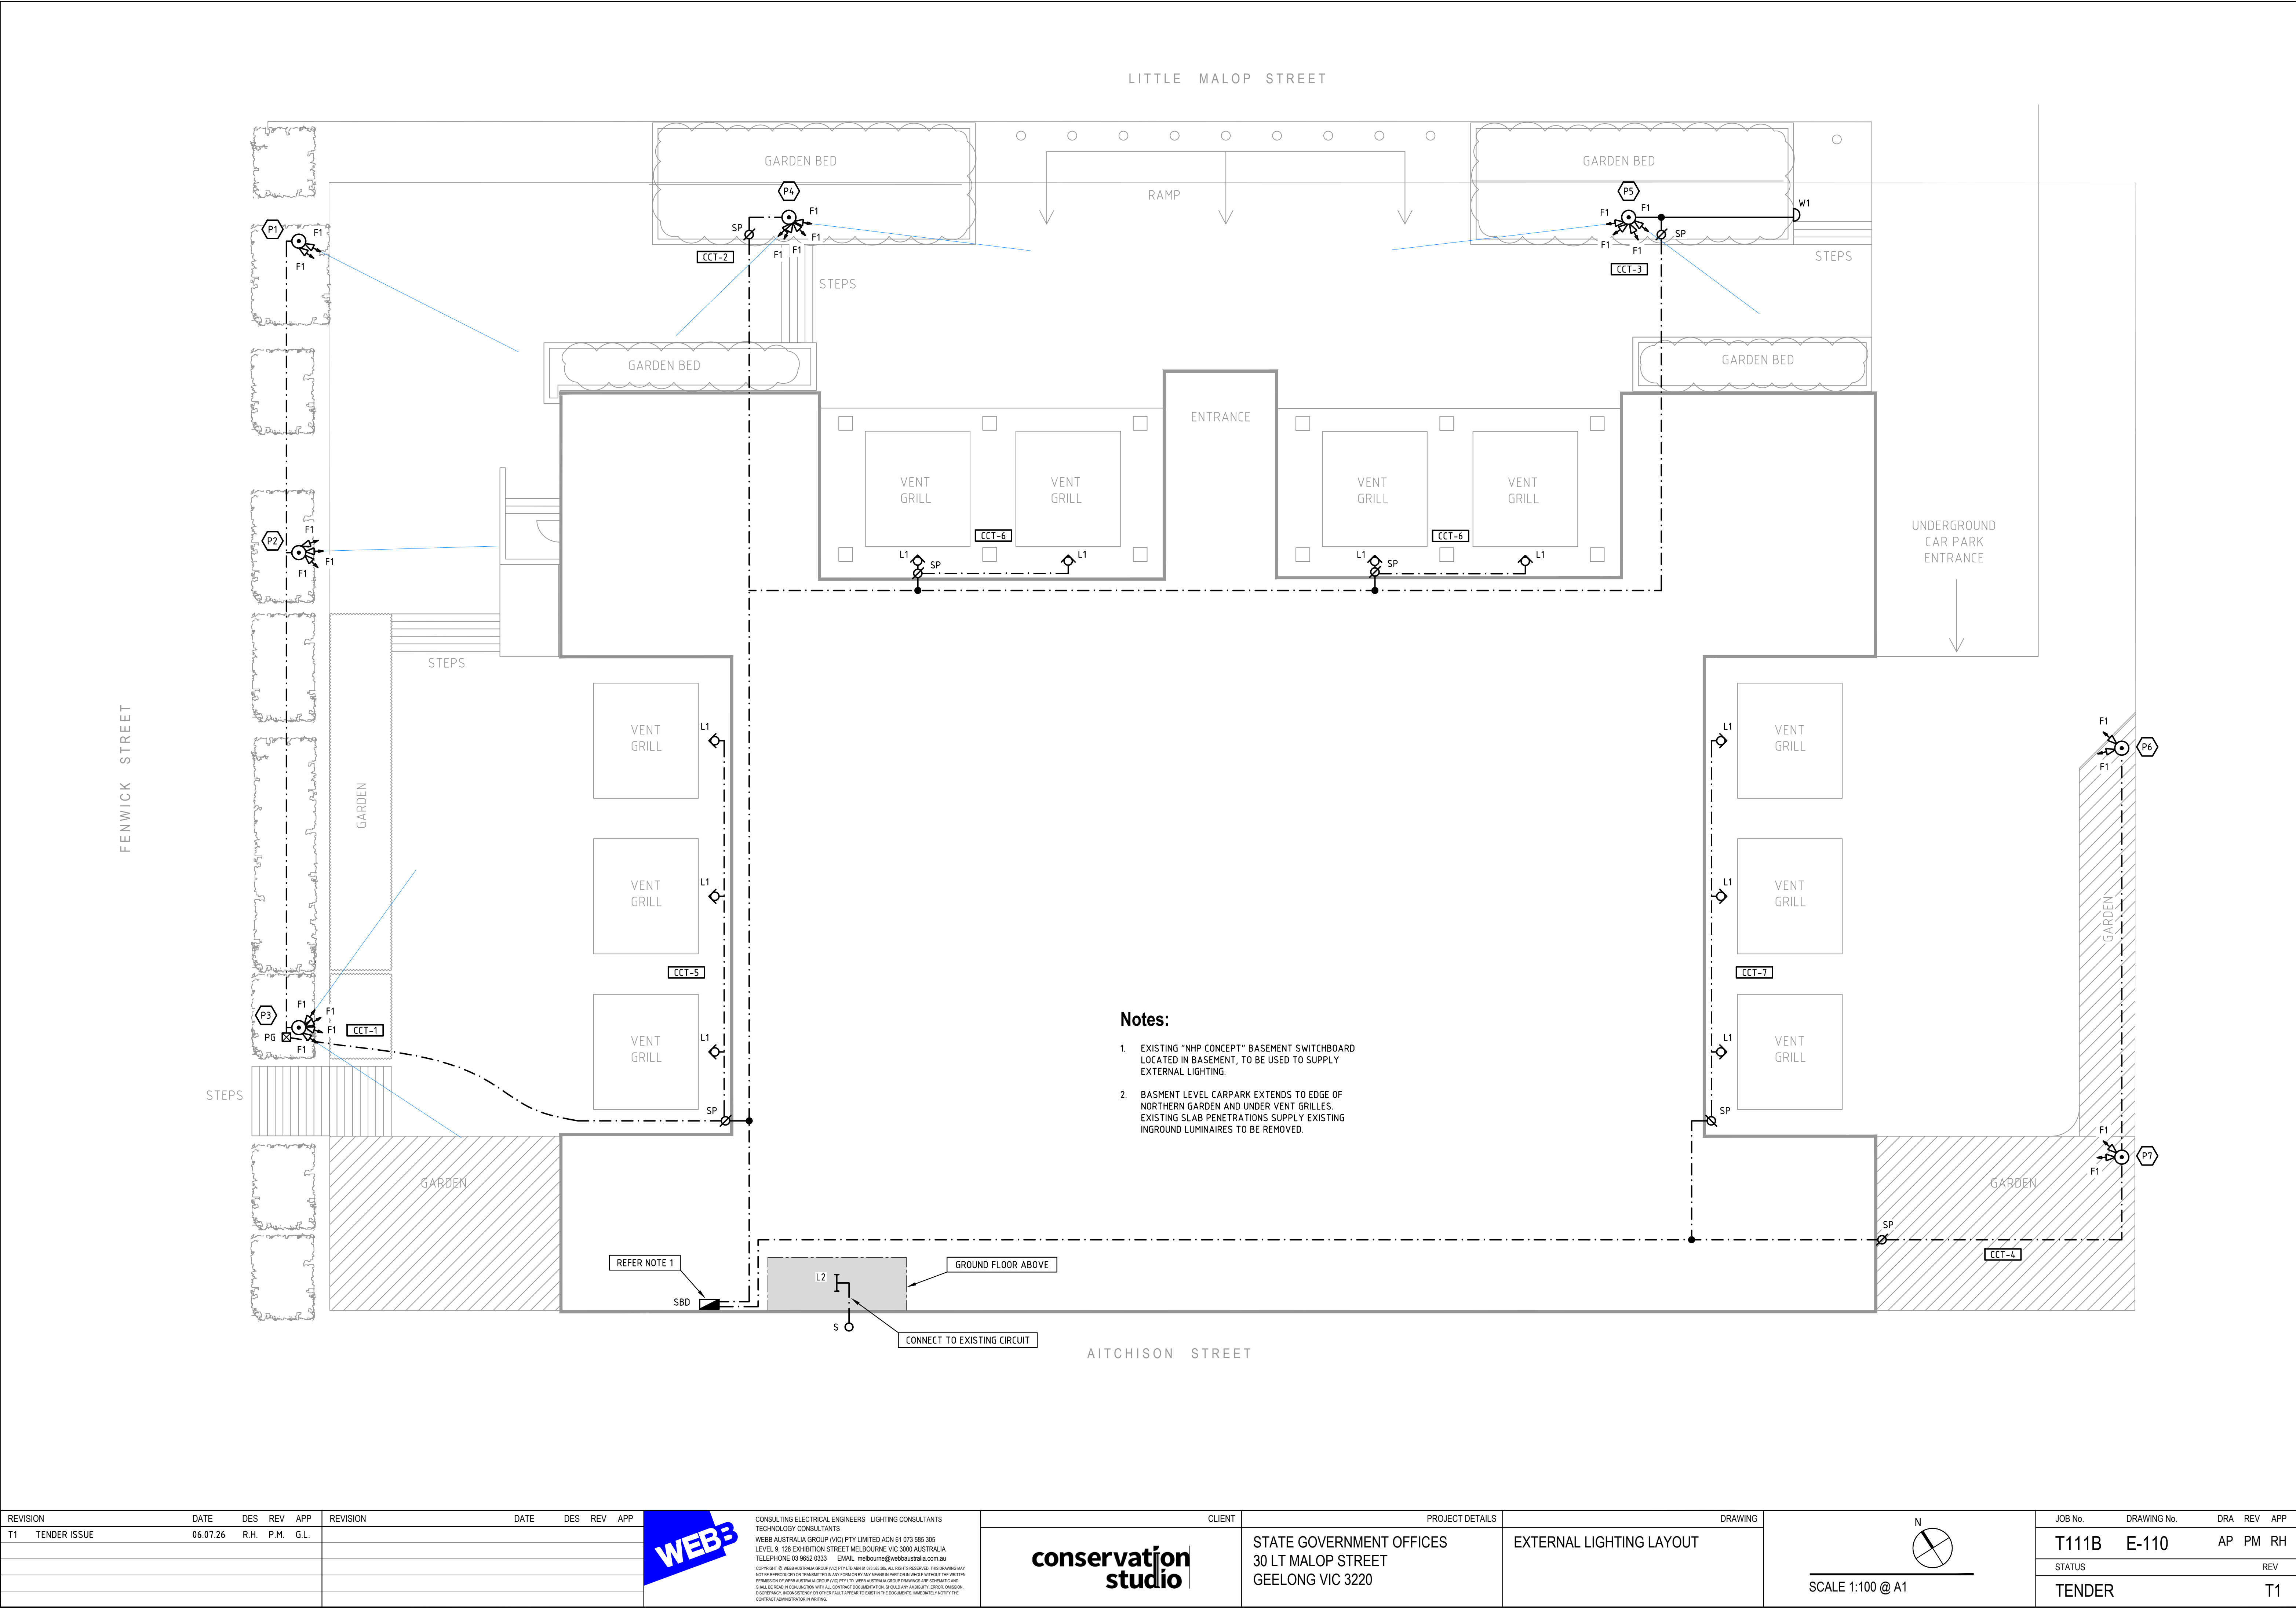



1. ALL FASTENING HARDWARE TO BE HOT DIP GALVANIZED.
2. REFER STRUCTURAL DRAWINGS FOR ORIGINAL DESIGN.
3. HEIGHT OF FOUNDATION SHALL BE SIZED TO SUIT GARDEN BED DEPTH. BASE PLATE TO BE LOCATED AT FINISHED GARDEN GROUND LEVEL.

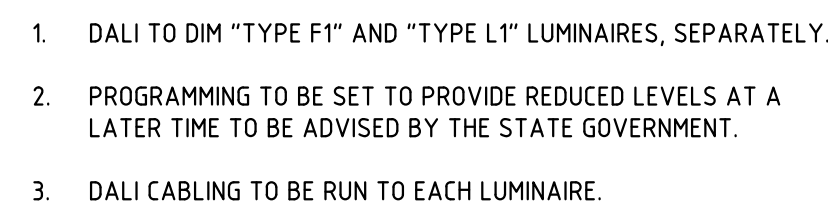

REVISION		DATE	DES	REV	APP	REVISION		DATE	DES	REV	APP	WEBB CONSULTING ELECTRICAL ENGINEERS LIGHTING CONSULTANTS TECHNOLOGY CONSULTANTS WEBB AUSTRALIA GROUP (VIC) PTY LIMITED ACN 61 073 585 305 LEVEL 9, 128 EXHIBITION STREET MELBOURNE VIC 3000 AUSTRALIA TELEPHONE 03 9652 0333 EMAIL info@webb.com.au COPYRIGHT © WEBB AUSTRALIA GROUP PTY LTD. ALL RIGHTS RESERVED. THIS DOCUMENT MAY NOT BE REPRODUCED OR TRANSMITTED IN ANY FORM OR BY ANY MEANS IN PART OR AS A WHOLE WITHOUT THE WRITTEN PERMISSION OF WEBB AUSTRALIA GROUP PTY LTD. VICTORIA AND SOUTH AUSTRALIA GROUP DRAWINGS AND DETAILS SHALL BE READ IN CONJUNCTION WITH ALL CONTRACT DOCUMENTATION SHOULD ANY AMBIGUITY, ERROR, OMISSION, DISCREPANCY, INADEQUACY OR OTHER FLAW APPEAR TO EXIST IN THE DOCUMENTS IMMEDIATELY NOTIFY THE CONTRACT ADMINISTRATOR IN WRITING.	CLIENT	PROJECT DETAILS	DRAWING	SCALE N/A @ A1	JOB No.	DRAWING No.	DRA	REV	APP
T1	TENDER ISSUE	06.07.26	R.H.	P.M.	G.L.								T111B	E-130	AP		PM	RH			
T2	TENDER REVISION	07.08.26	R.H.	P.M.	G.L.																
													conservation studio	STATE GOVERNMENT OFFICES 30 LT MALOP STREET GEELONG VIC 3220	SCHEMATIC DIAGRAMS AND DETAILS			STATUS	REV	TENDER	T2